
DOCKETED	
Docket Number:	25-SPPE-02
Project Title:	NorthTown Backup Generating Facility (NTBGF)
TN #:	264504
Document Title:	NTBGF SPPE Application Appendix B - Part V of V
Description:	N/A
Filer:	Scott Galati
Organization:	DayZenLLC
Submitter Role:	Applicant Representative
Submission Date:	6/30/2025 8:37:54 AM
Docketed Date:	6/30/2025



CITY OF SAN JOSE APPROVAL

OWNER / APPLICANT:

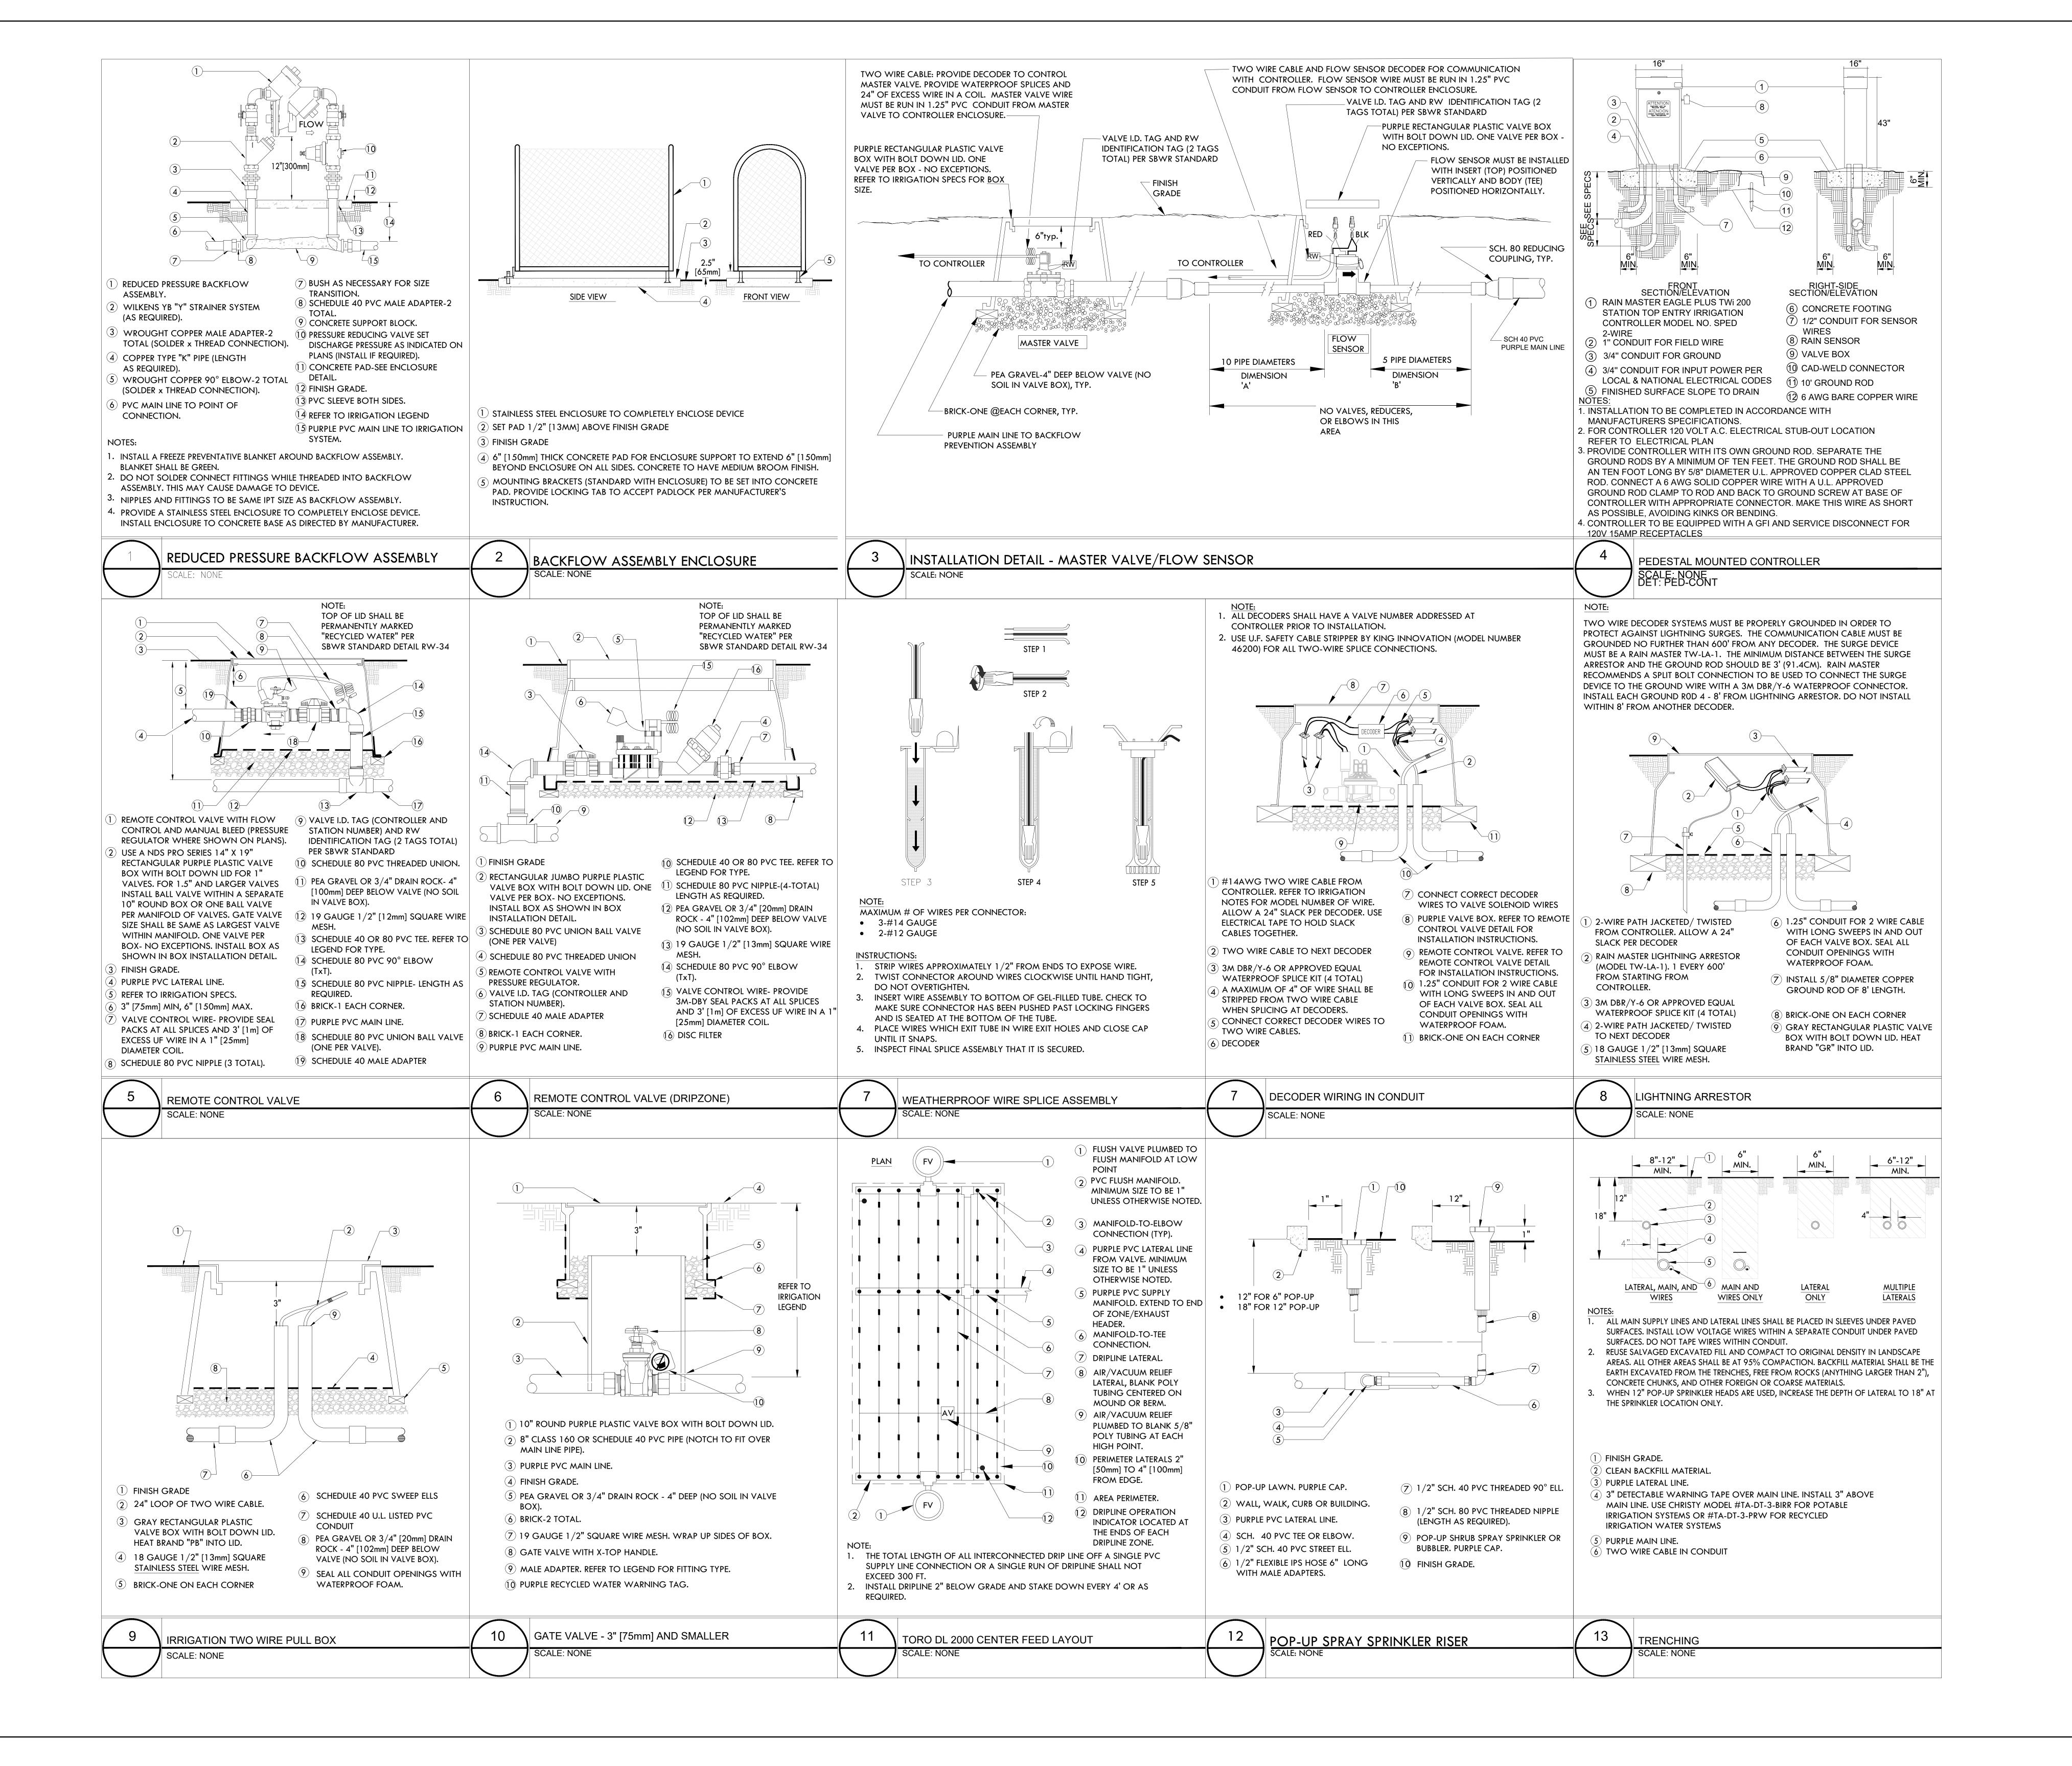

PROJECT TEAM:



PLANNER / LANDSCAPE ARCHITECT

KAYVICTOR

CIVIL ENGINEER / ARBORIST:



LIGHTING / ELECTRICAL ENGINEER:



NO. DATE REMARKS

1 06/16/2025 1st CUP Submittal

NORTHTOWN DATA CENTER DC WEST

370 W. Trimble Road San Jose, CA 95131

PERMIT TYPE:

Conditional Use Permit

PERMIT REF: CUP25-TBD

AUTHORED BY: KAYVICTOR

DRAWN BY: GG
CHECKED BY: JV


JOB REF: 2404

IRRIGATION DETAILS

SHEET:

TITLE:

L5.2

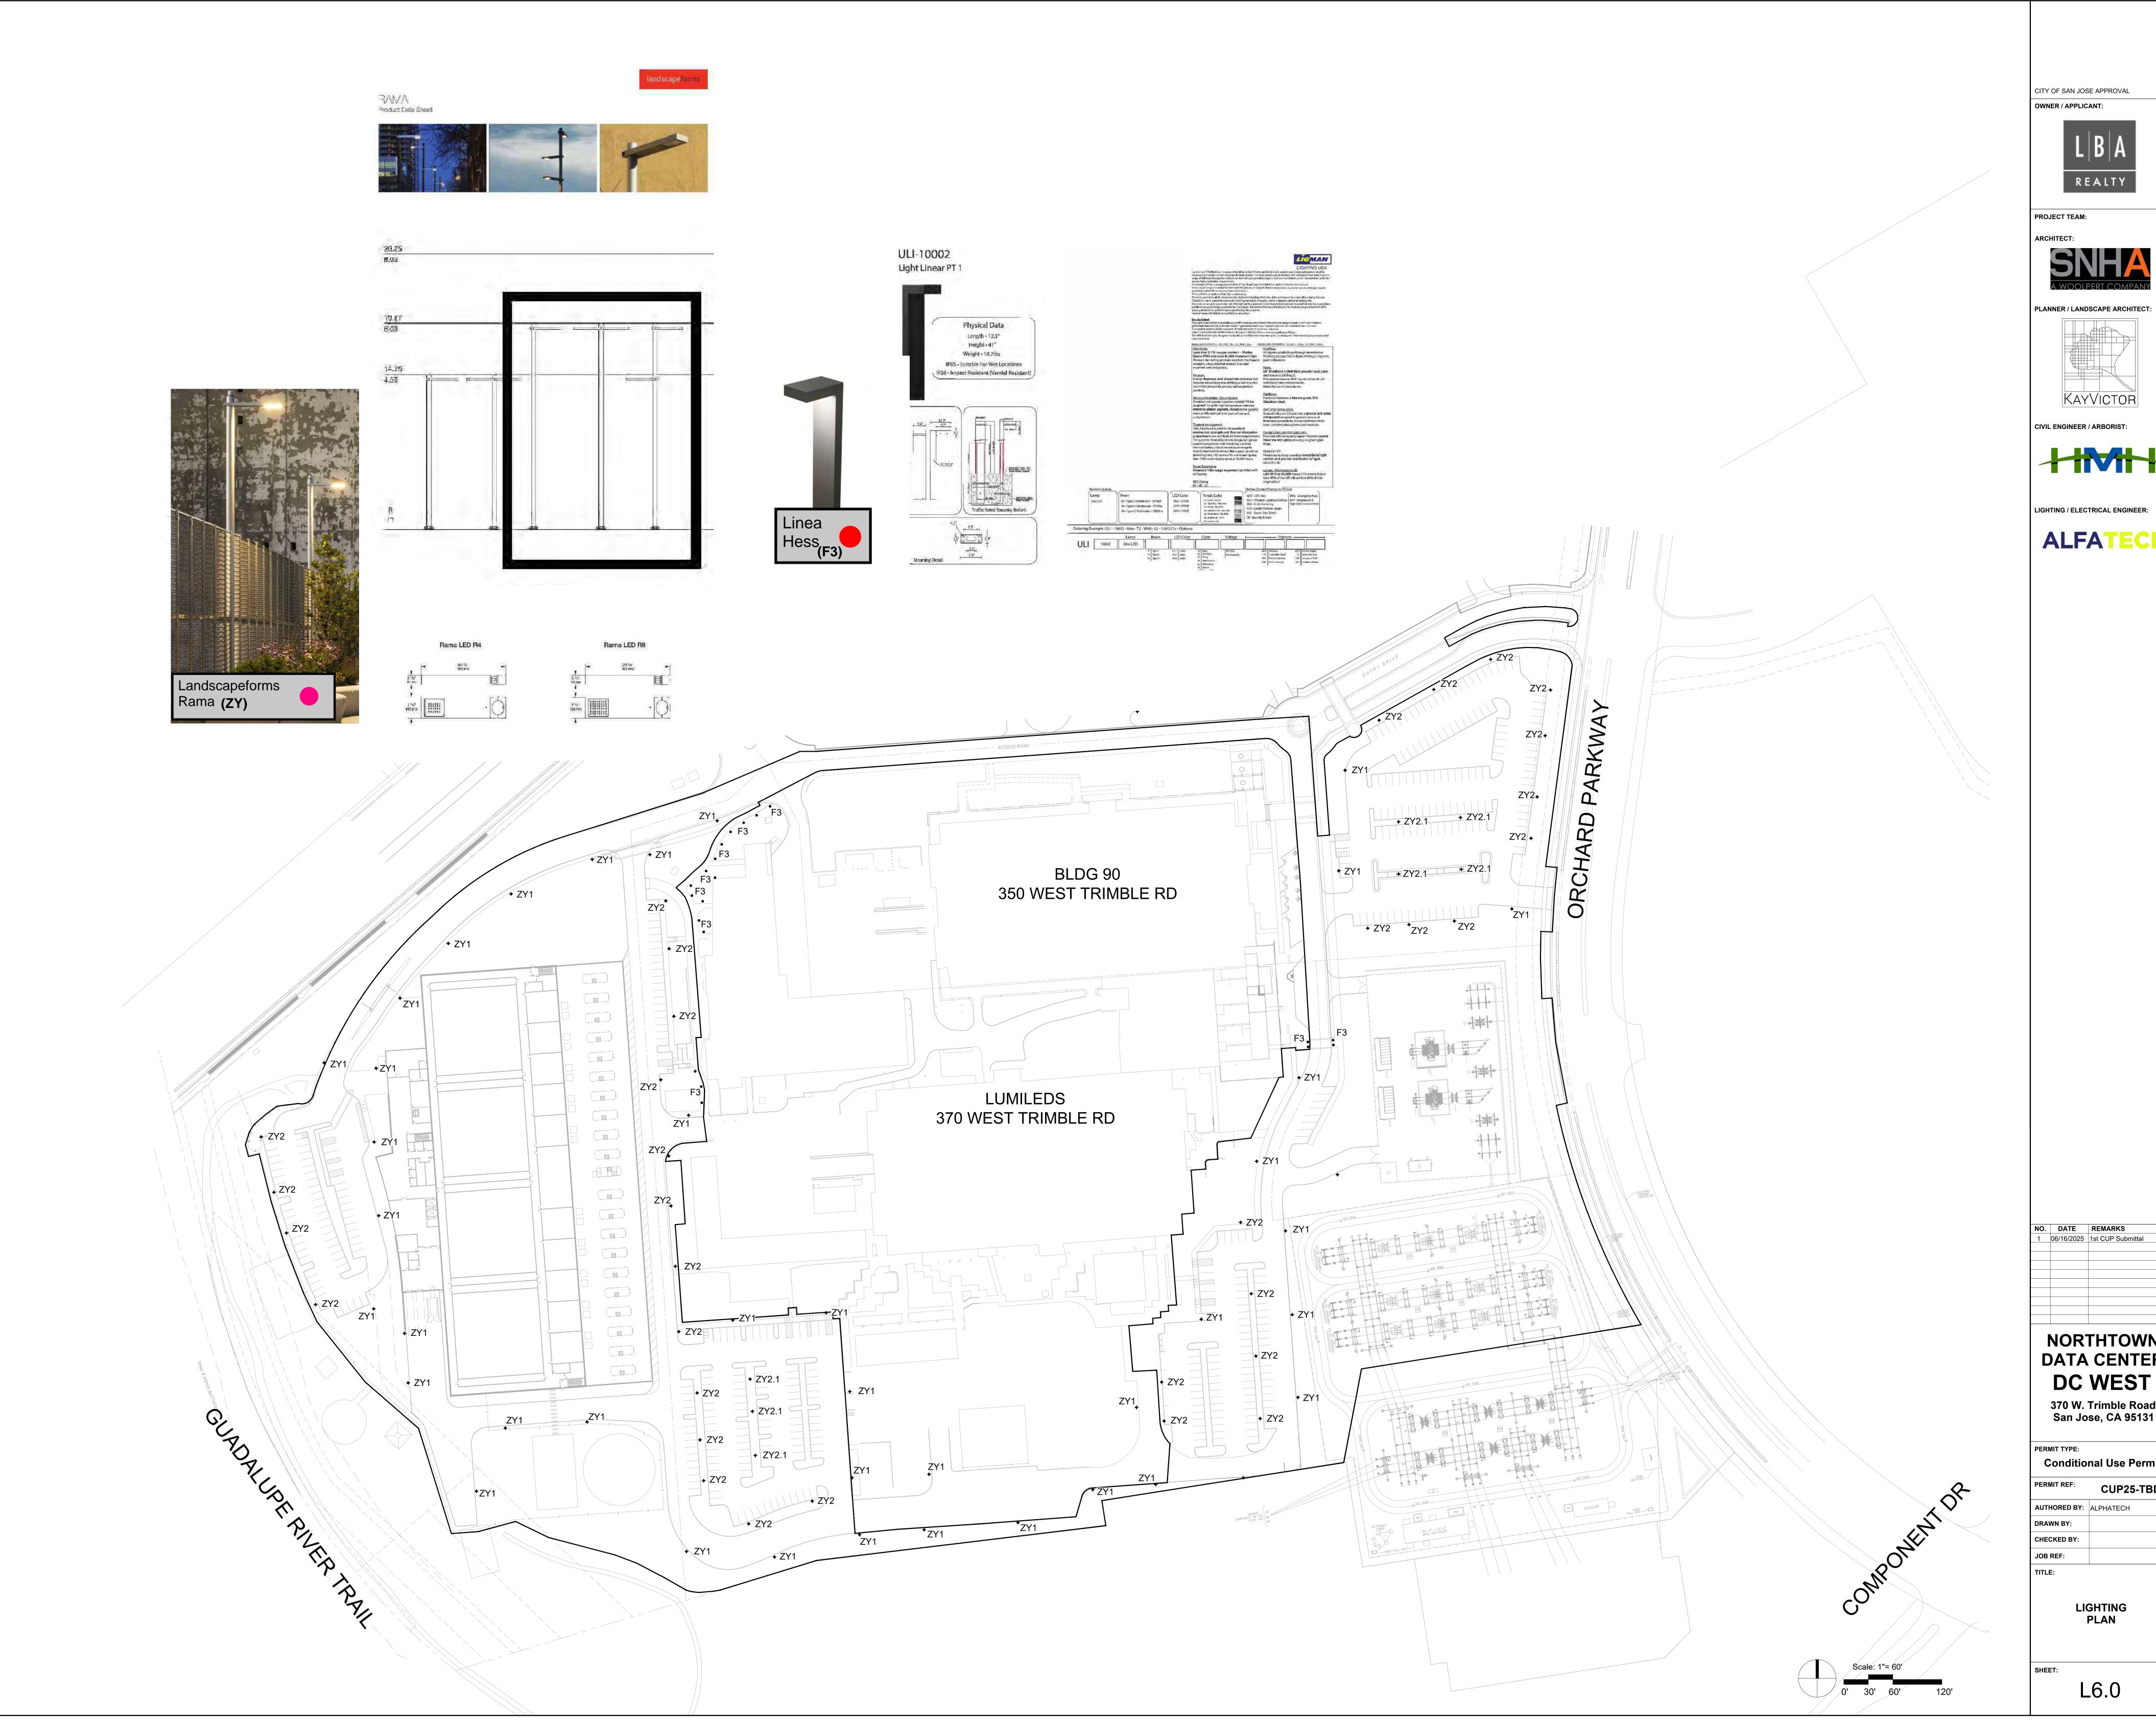

CITY OF SAN JOSE APPROVAL





PLANNER / LANDSCAPE ARCHITECT:



LIGHTING / ELECTRICAL ENGINEER:



 NO.
 DATE
 REMARKS

 1
 06/16/2025
 1st CUP Submittal

NORTHTOWN DATA CENTER


370 W. Trimble Road San Jose, CA 95131

Conditional Use Permit

CUP25-TBD AUTHORED BY: ALPHATECH

LIGHTING PLAN

L6.0

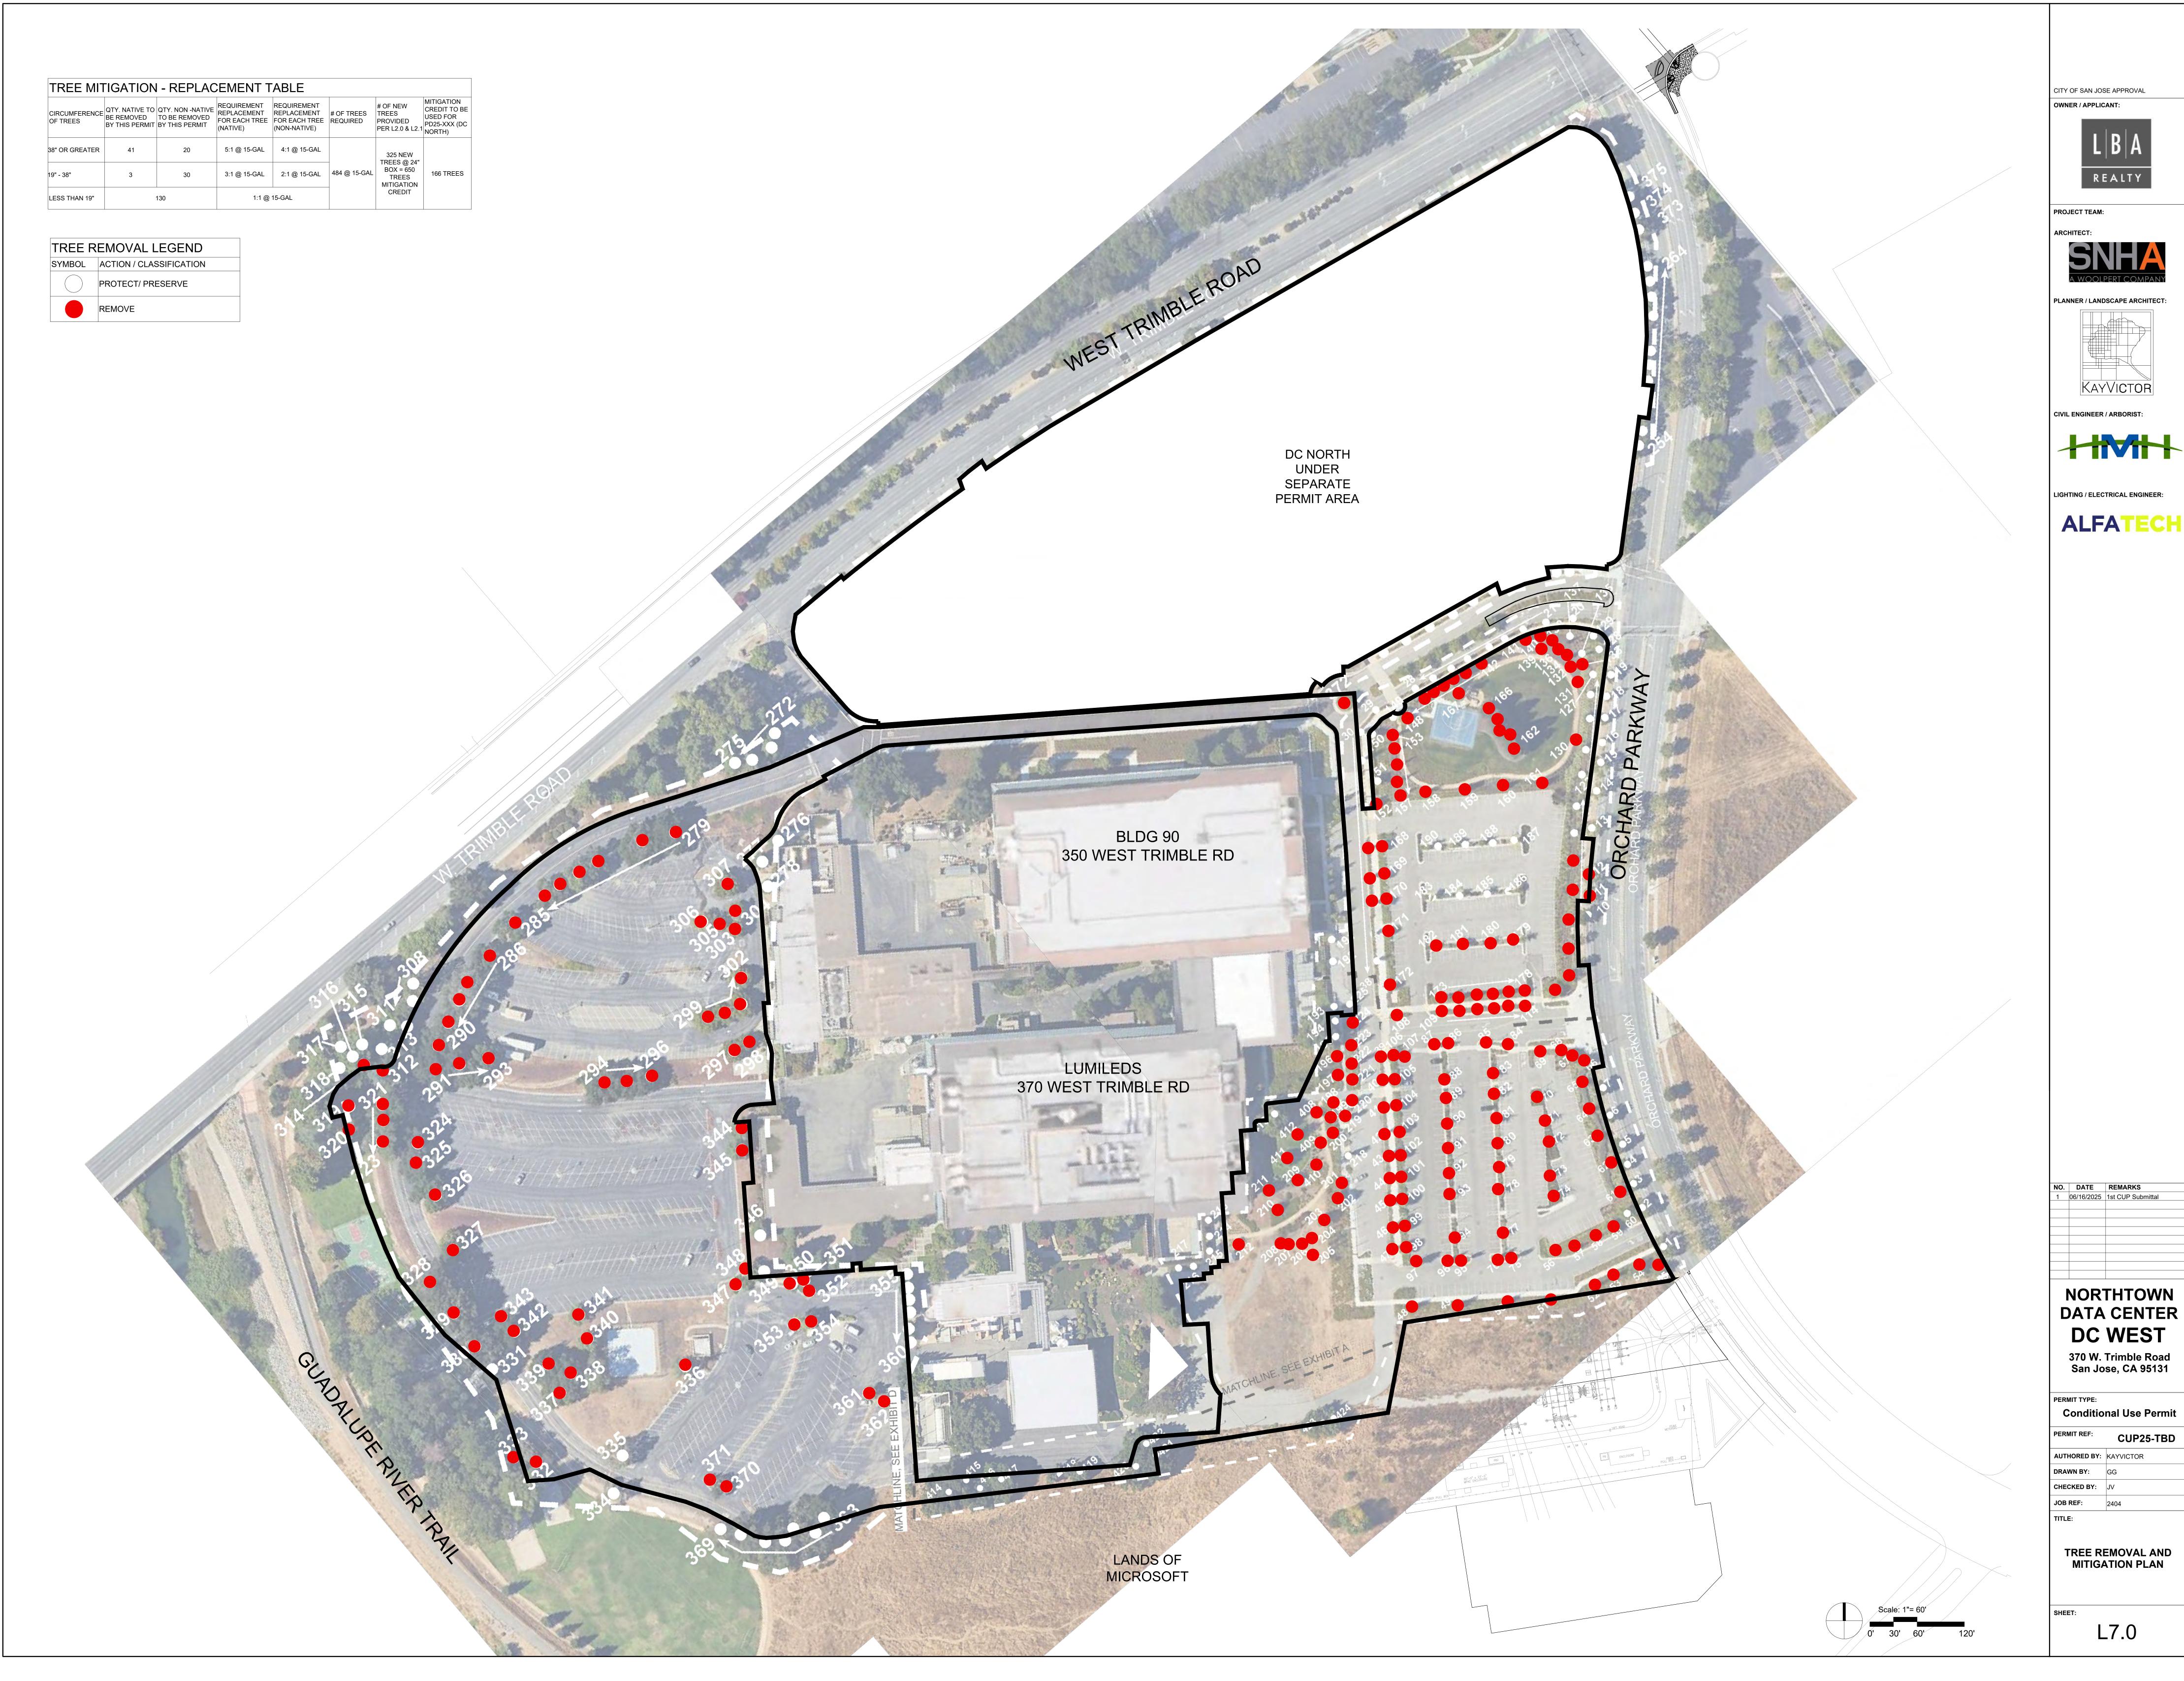







423 Salix amygdaloides Peachleaf Willow 6.4, 10, 9.2, 7.3, 10.1, 9.5, 5.8, 6.3 YES Non-native 4:1 33 30 3 Moderate

| 424 | Salix amygdaloides | Peachleaf Willow | 6.2, 8.8, 6, 6, 6.4, 7.1 | 127 | YES | Non-native | 4:1 | 28 | 28 | 3 | Moderate |

OWNER / APPLICANT:



PROJECT TEAM:



A WOOLPERT COMPANY

PLANNER / LANDSCAPE ARCHITECT

KAYVICTOR

CIVIL ENGINEER / ARBORIST:

LIGHTING / ELECTRICAL ENGINEER:



NO. DATE REMARKS

1 06/16/2025 1st CUP Submittal

NORTHTOWN DATA CENTER DC WEST

370 W. Trimble Road San Jose, CA 95131

ERMIT TYPE:

Conditional Use Permit

PERMIT REF:

CUP25-T

AUTHORED BY: KAYVICTOR

DRAWN BY: GG

CHECKED BY: JV

JOB REF: 2404

TITLE:

ARBORIST REPORT

. - 4

.7.1