


**DOCKETED**

<b>Docket Number:</b>	79-AFC-04C
<b>Project Title:</b>	Compliance - Application for Certification of DWR Bottlerock Geothermal Project
<b>TN #:</b>	268605
<b>Document Title:</b>	Bottle Rock Overall SLD
<b>Description:</b>	Overall SLD for the project.
<b>Filer:</b>	John C Casteel
<b>Organization:</b>	Mayacma Geothermal LLC
<b>Submitter Role:</b>	Applicant
<b>Submission Date:</b>	2/12/2026 3:47:33 PM
<b>Docketed Date:</b>	2/12/2026

ALS 1/26/2024 2:29 PM  
C:\Users\alec\OneDrive\Documents\Projects\05-10-Terra Tech\Mayacma Geothermal\New ORC Drawing\E-1001 Overall One Line.dwg

PLOTTED: 3/15/2024 4:29 PM  
C:\Users\alec\OneDrive\Documents\Projects\05-10-Terra Tech\Mayacma Geothermal\New ORC Drawing\E-1001 Overall One Line.dwg

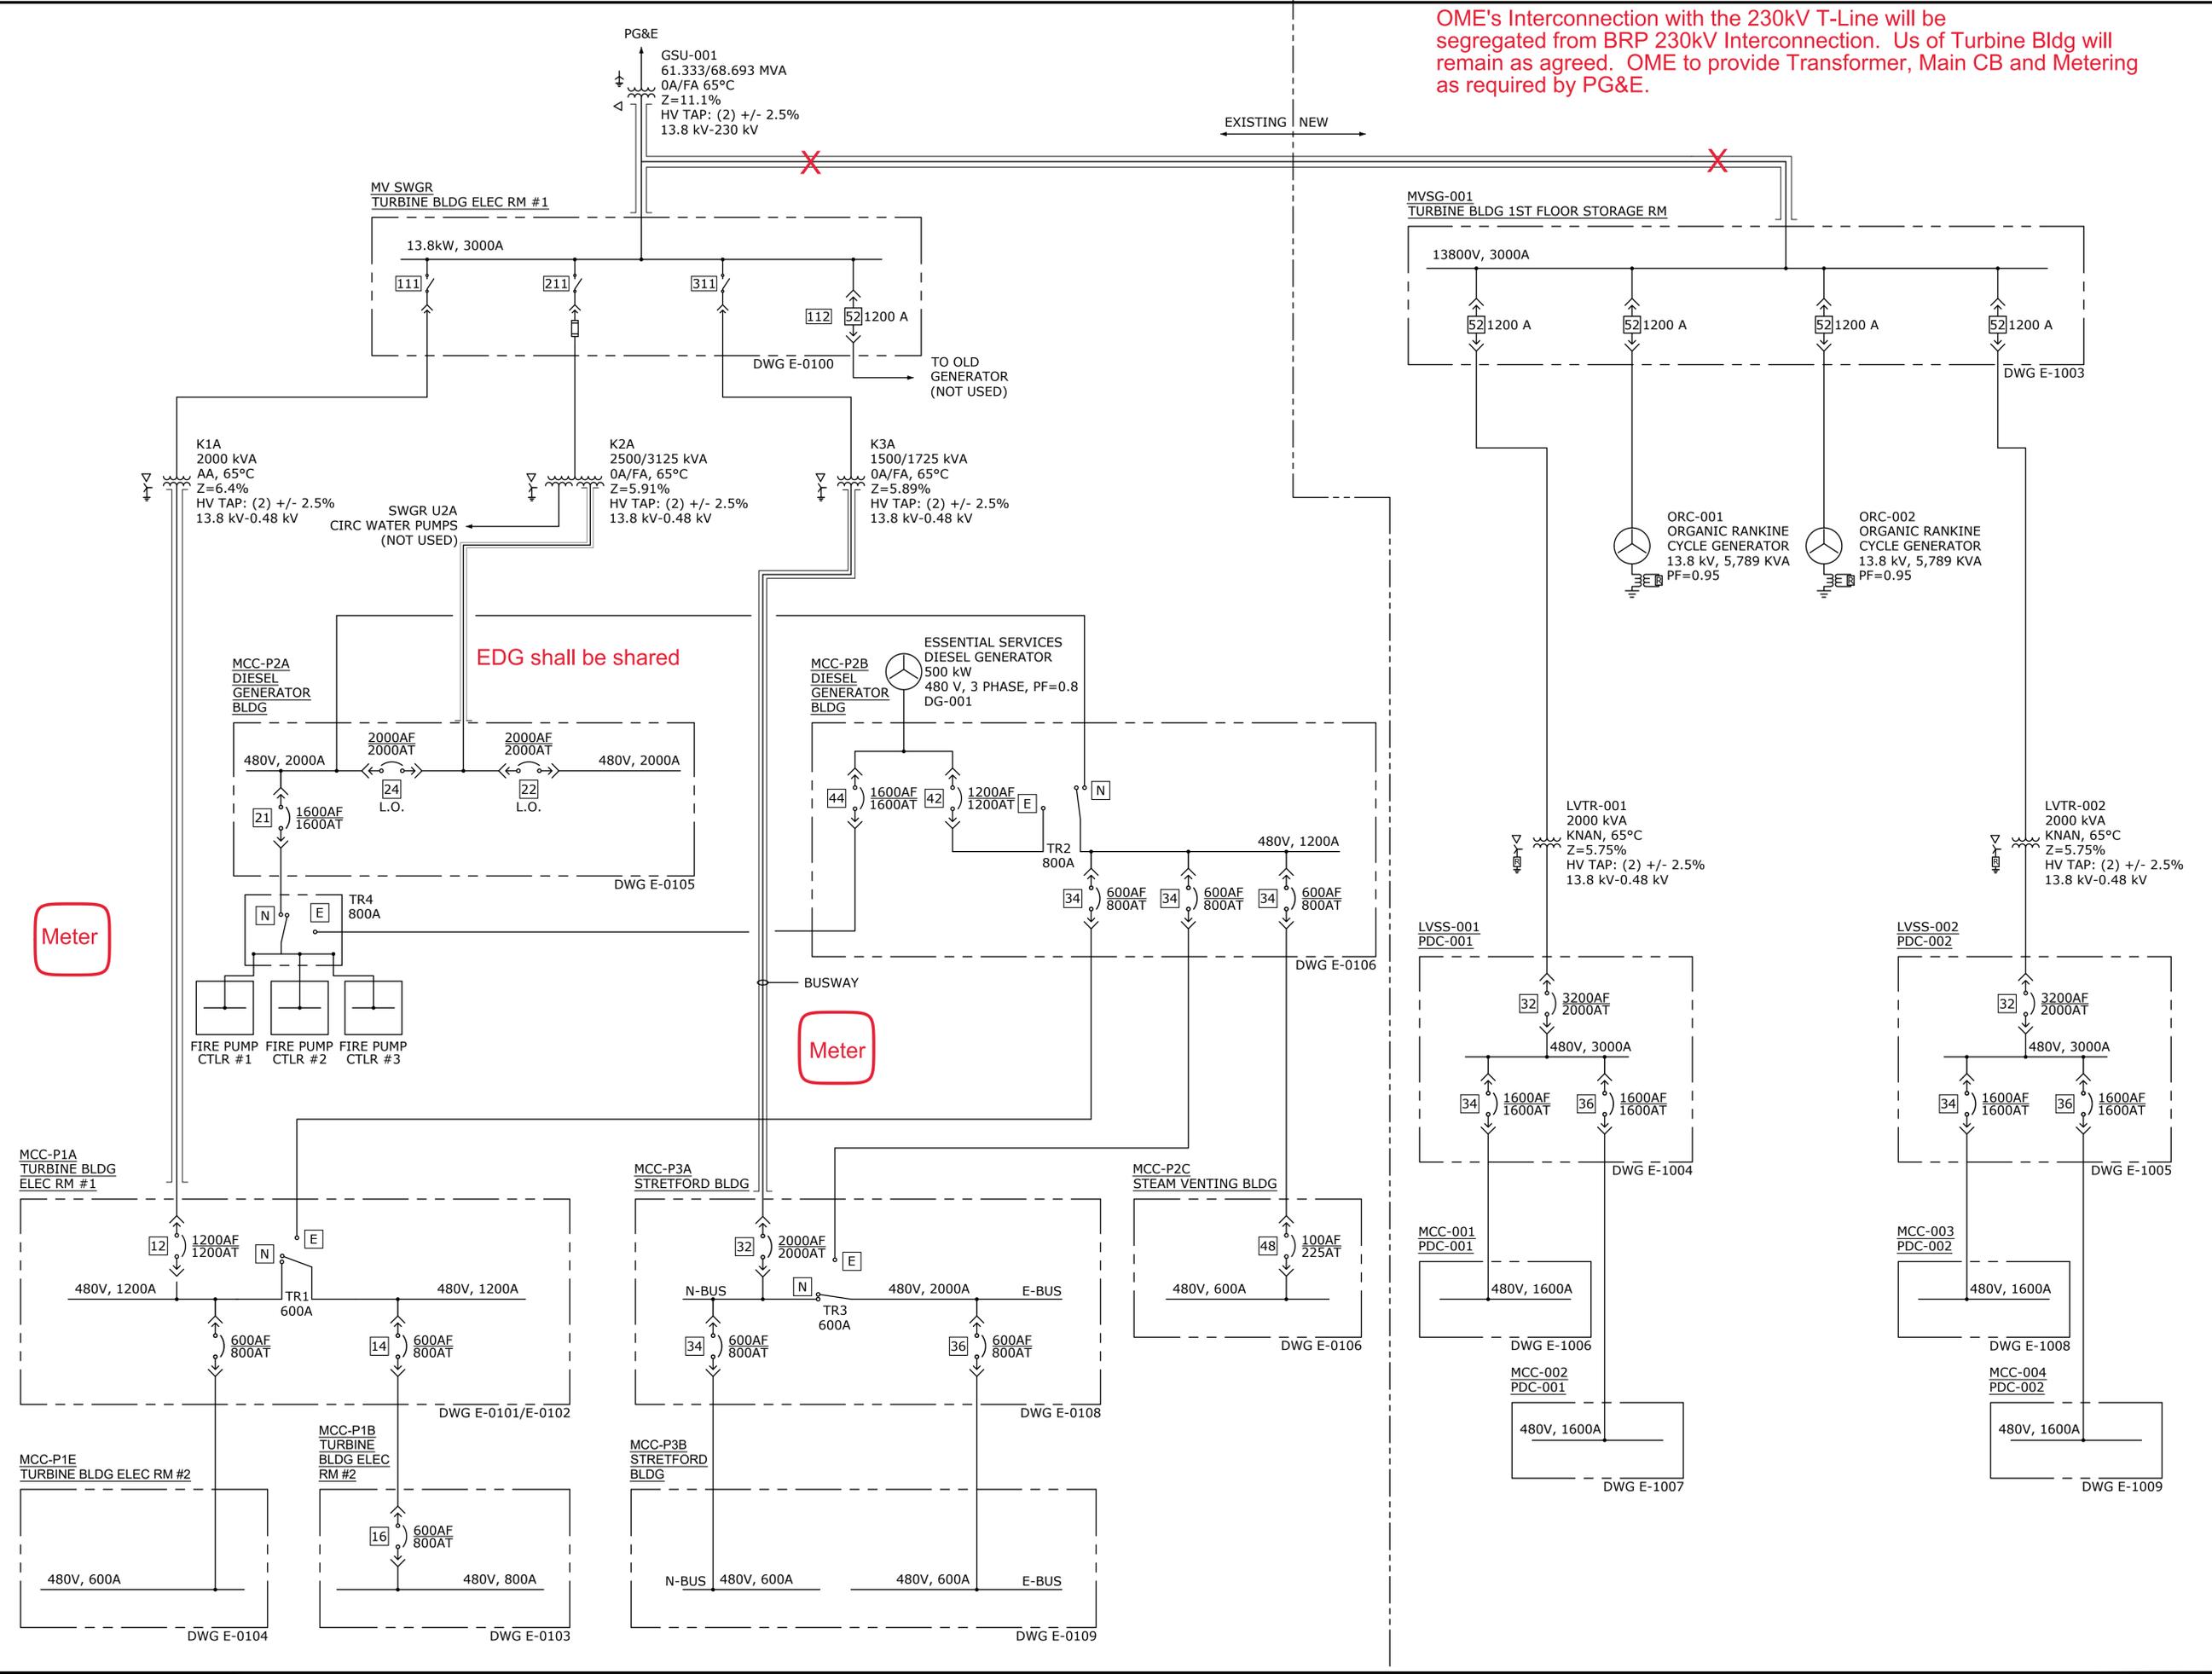

OME's Interconnection with the 230kV T-Line will be segregated from BRP 230kV Interconnection. Us of Turbine Bldg will remain as agreed. OME to provide Transformer, Main CB and Metering as required by PG&E.



3451 N Triumph Blvd Ste 201, Lehi, UT 84043.  
(385) 352-8858



TETRA TECH, INC.  
4101 COX ROAD,  
SUITE 120  
GLEN ALLEN, VA 23060  
TEL: (804) 290-4321  
FAX: (804) 270-2739

PE STAMP:

**PRELIMINARY**  
NOT FOR CONSTRUCTION

KEY PLAN:

REVISIONS:

NO.	DATE	DESCRIPTION
A	11/08/2022	PRELIMINARY
B	03/17/2023	ISSUED FOR 25% REVIEW

PROJECT TITLE:

MAYACMA GEOTHERMAL LLC  
REPOWER PROJECT

PROJECT LOCATION:

7385 HIGH VALLEY ROAD  
COBB, CA 95426

SHEET TITLE & DESCRIPTION:

OVERALL ONE-LINE  
DIAGRAM

ONE-LINE DIAGRAM

PROJ NUM:	194-G0437
DES:	A. GREENE
DWN:	A. COLISTA
CHK:	J. ABBATE
APV:	C. LUNDQUIST
DATE:	11/08/2022

SCALE AT 24" x 36":  
NONE

SHEET NO:	E-1001	REV:	B
-----------	--------	------	---